


01  
P09  
ROOF PLAN & SW DRAINAGE LAYOUT - EXISTING  
SCALE 1:100 @ A1

**BALLYROAN COMMUNITY  
& YOUTH CENTRE**

SHEET P09  
ROOF PLANS WITH SW DRAINAGE - EXISTING AND PROPOSED

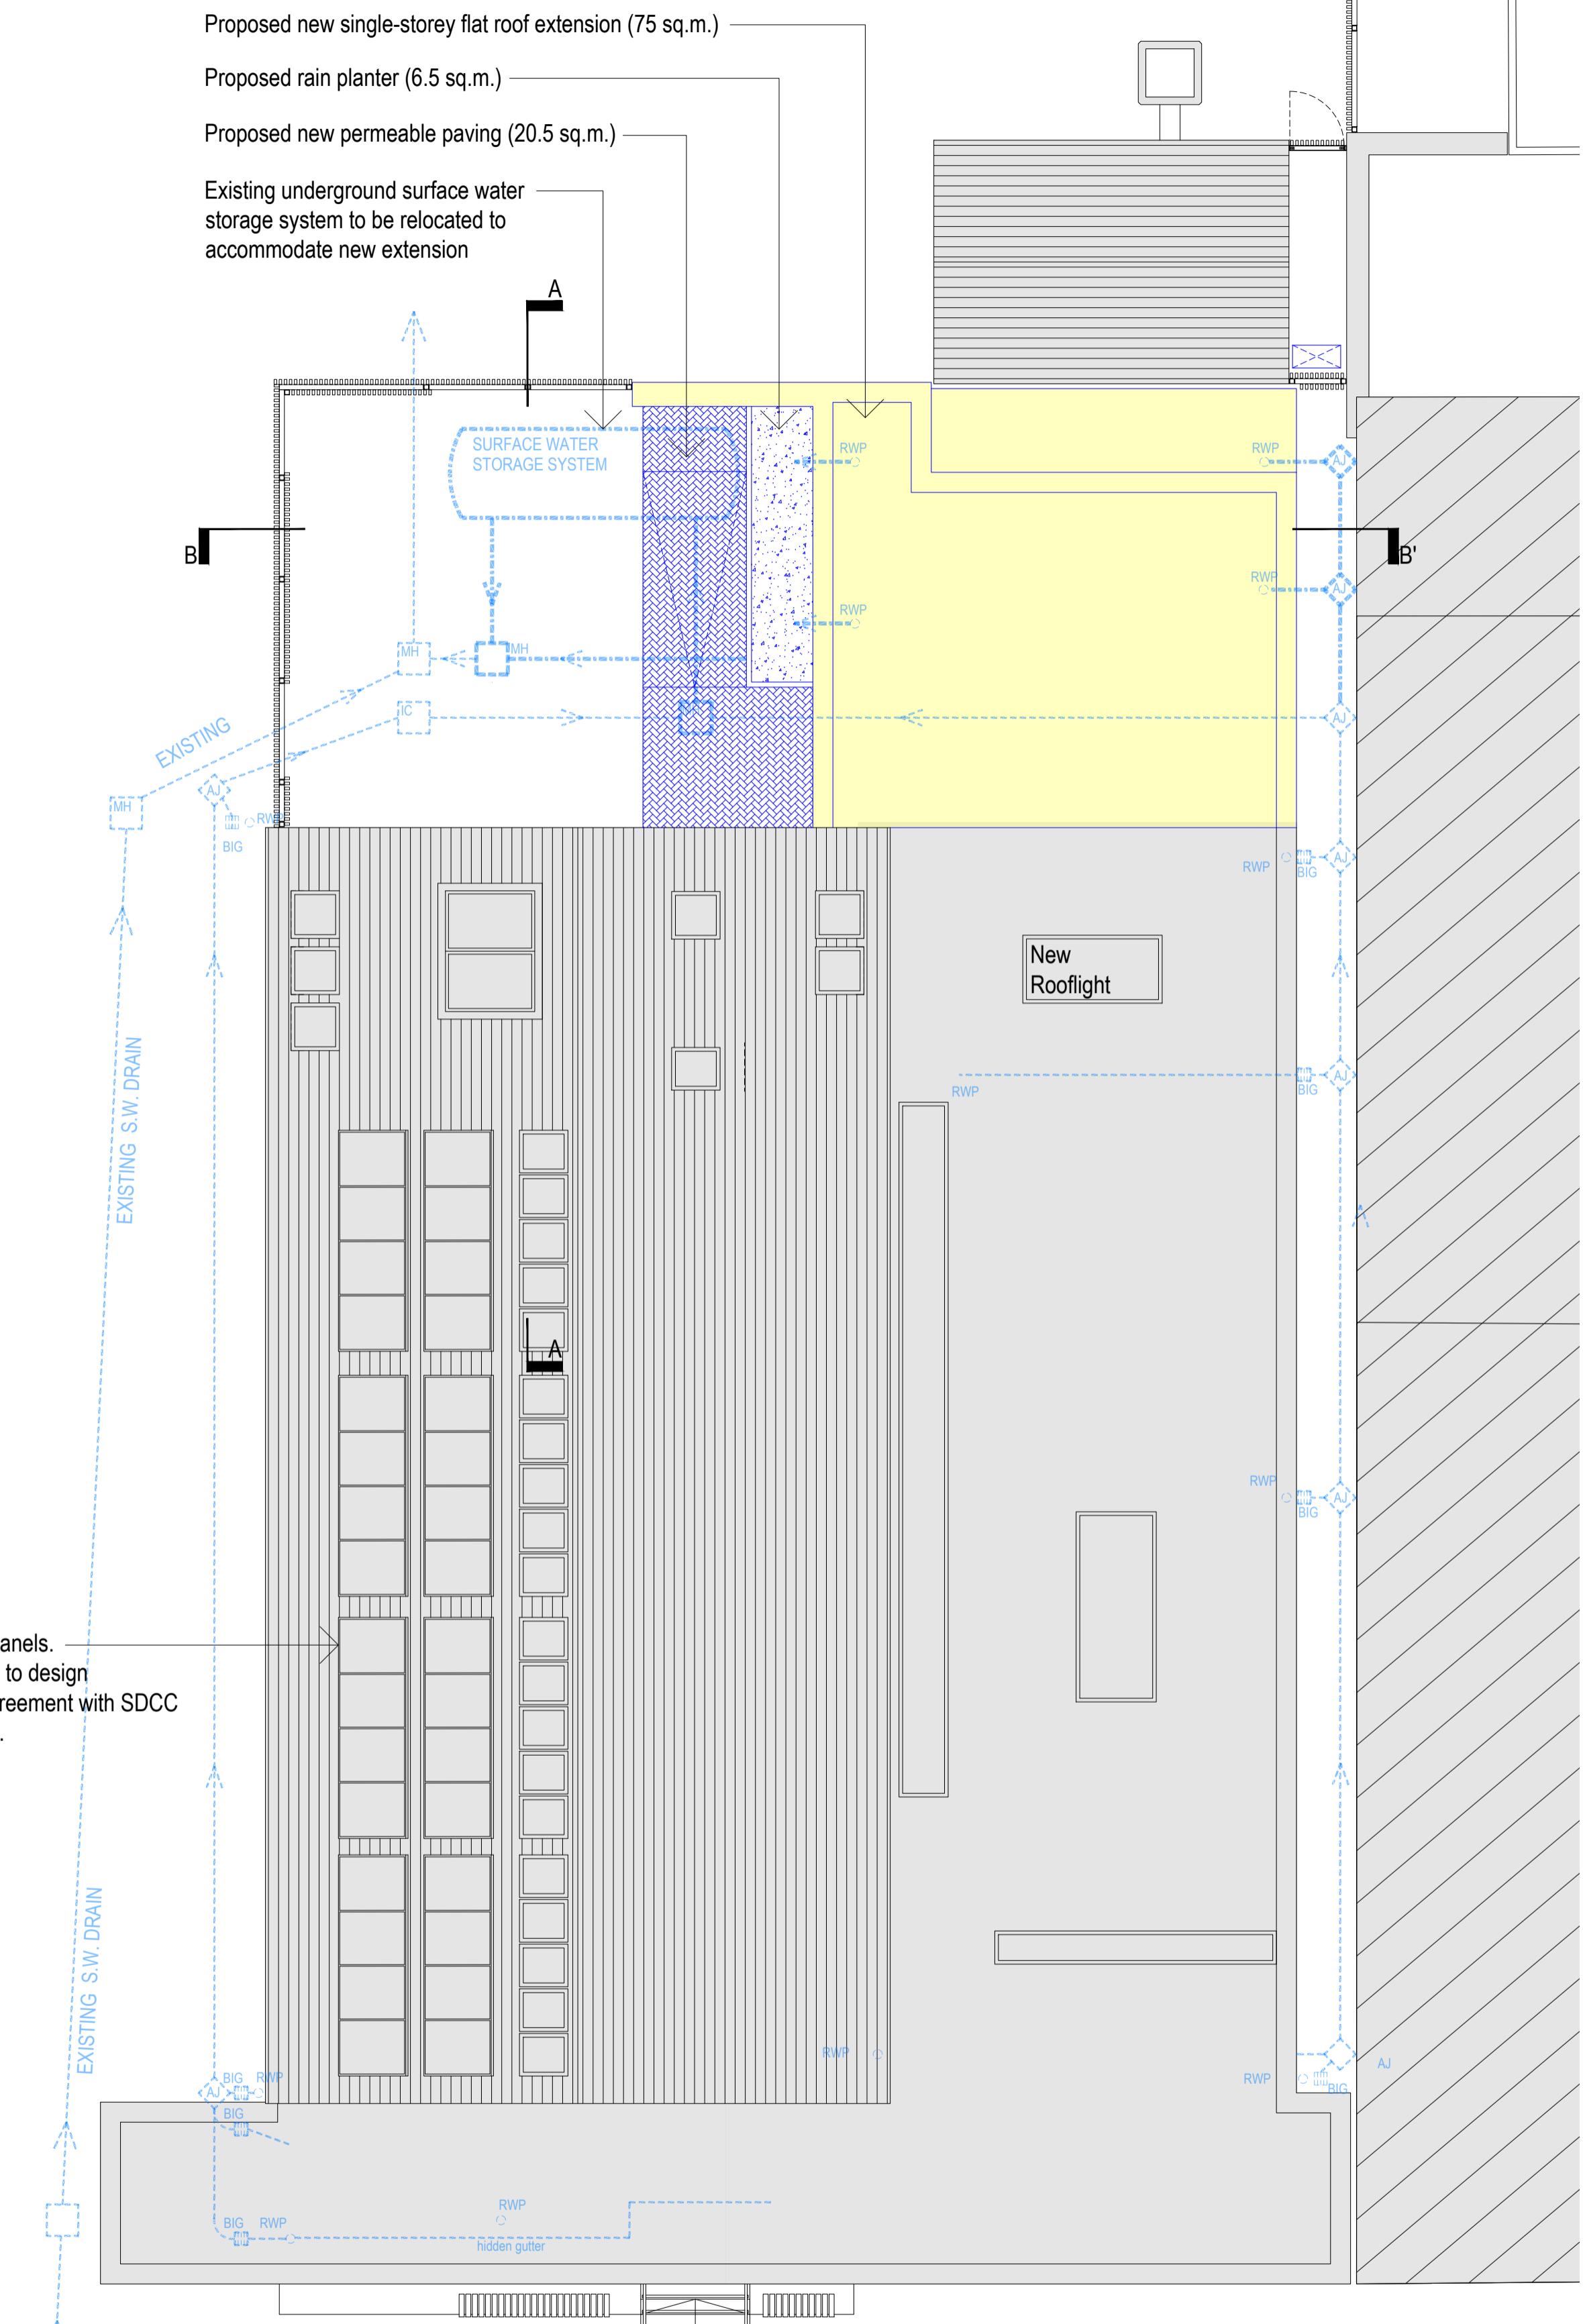

02  
P09  
ROOF PLAN & SW DRAINAGE LAYOUT - PROPOSED  
SCALE 1:100 @ A1

**PART 8  
2025**